




Legend of Site Plan Padkhab Roghani School

| | |
|---|-------------------------------|
| A | Planed Building |
| B | Planed Latrines 5 |
| C | Planed Water well, Dept (50)m |
| D | Hand washing station(1) |
| E | Planed Boundary wall(600m) |

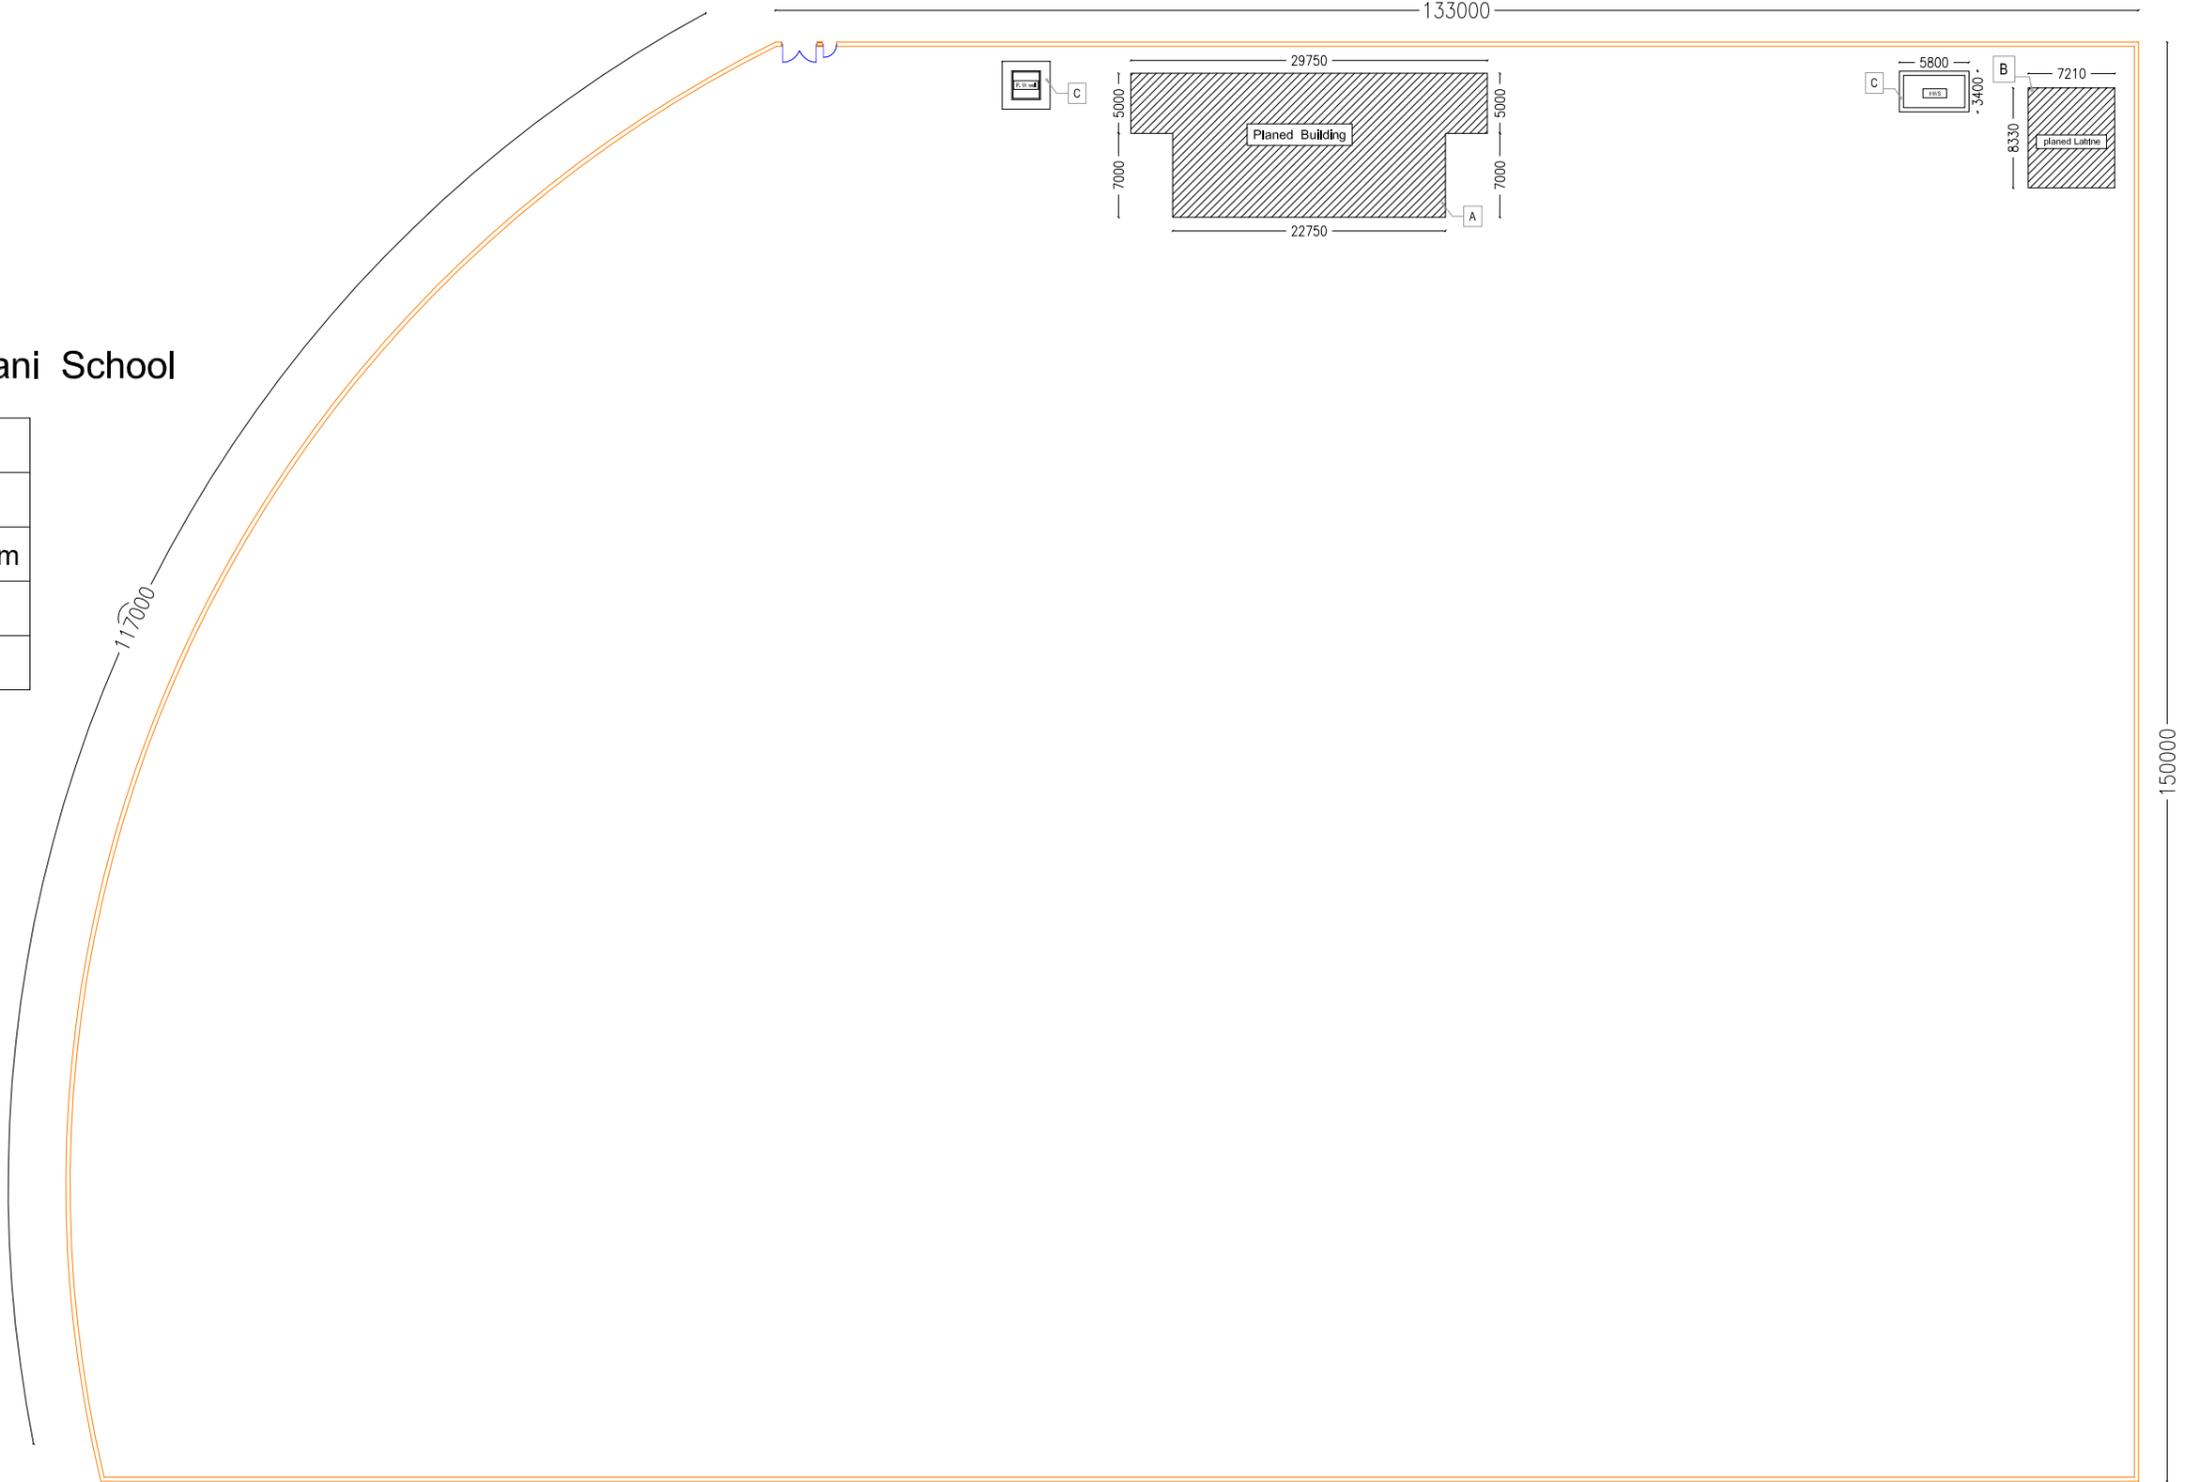

01 Site Plan OF Padkhab Roghani School

N/S

- 1.The planed activities will be constructed based on the site condition
2. All dimensions are in mm unless otherwise specified



Ministry of Education Infrastructure service
Department (I.S.D)

| | |
|----------------------------------|-----------------------|
| Designed by: | |
| Drawn by: | Eng Zabihullah Ferozi |
| Checked By WASH Focal point : | Eng Nazifullah Akrami |
| Approved by Visa Committee: | |

| No. | Submission Description: | Date: |
|-----|--|------------|
| 01 | For Tender(It drawn from primary data) | 21/06/2023 |
| | | |
| | | |

| | |
|----------------|----|
| Contract No: | |
| Contract Date: | |
| Fiscal Year: | |
| Drawn Code: | |
| Paper Size: | A3 |
| Plot Date: | |
| Scale: | |

ISD (Ministry of Education Infrastructure Service Department)
Padkhab Roghani School - Logar , Afghanistan

School Code
503000005